A - EASEMENT FOR GAS PIPELINES B - EASEMENT FOR OPTIC FIBRE CABLE C - EASEMENT FOR WATER SUPPLY

ROAD

CROOKWELL

A

B

C




TITLE PARTICULARS: LOTS 70, 73 & 77 DP1006688

DRAWING TITLE: STRATEGIC BUSH FIRE STUDY -BUSH FIRE HAZARD ASSESSMENT SITE PLAN

PROJECT TITLE: LAND REZONING PROPOSAL -CONCEPTUAL SUBDIVISION PLAN

A

B

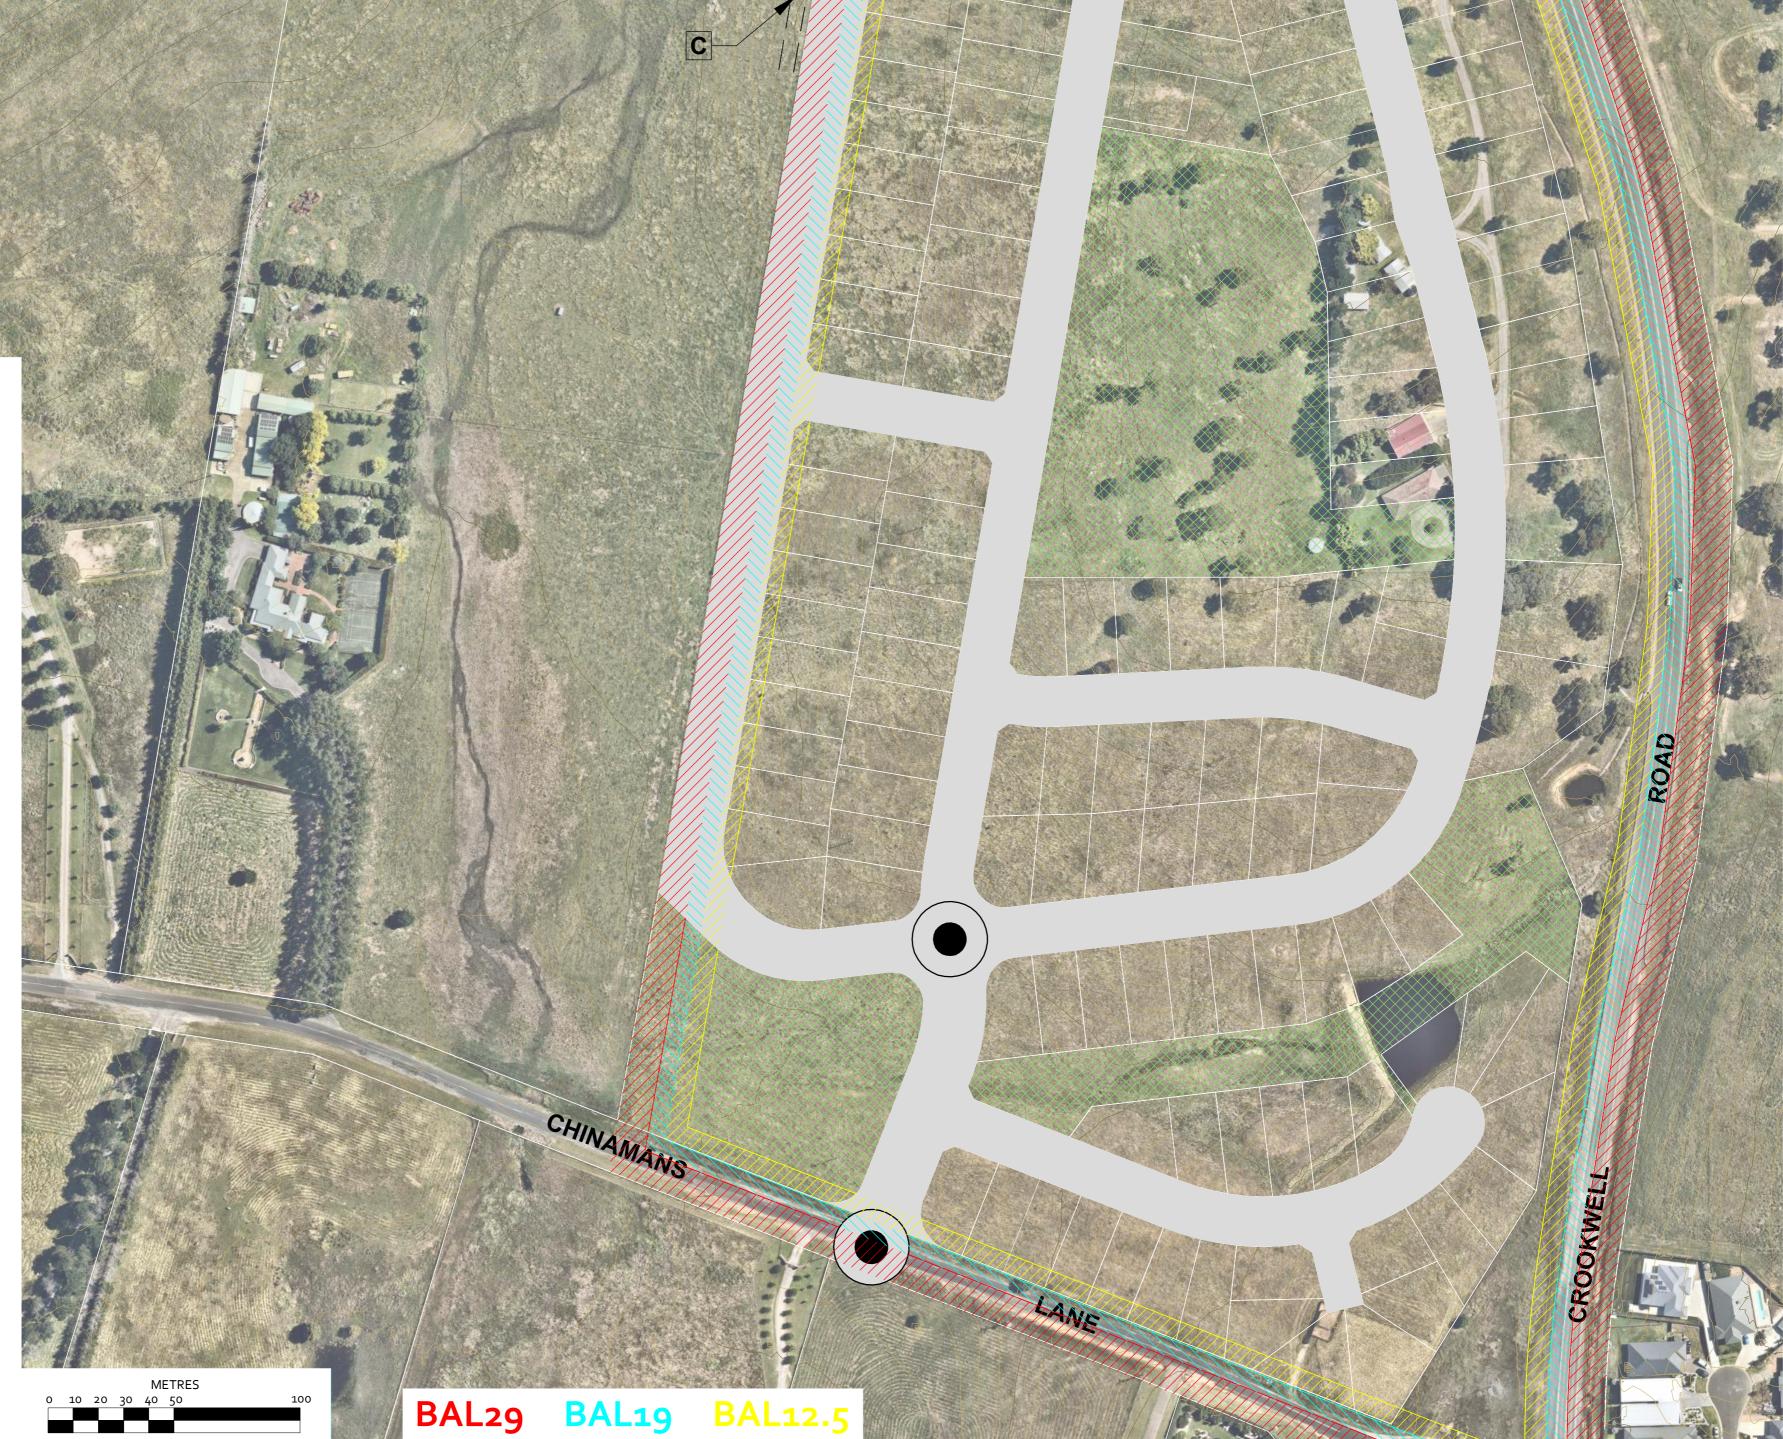



1



DRAWING DATE:	SHEET NUMBER:
Nov. 2022	1 of 1
REFERNCE NUMBER:	DRAWN BY:
0020421	PJ
DRAWING SCALE:	AT SHEET SIZE:
1:1,500	Aı
DRAWING REFERENCE N	UMBER:
0020421-01BF-	A
CONTOUR INTERVALS:	
MAJOR : 5 METRE MINOR: 1 METRE	
ISSUE / DATE	DRAWING REFERENCE
A	ISSUED FOR
19/11/2022	SUBMISSION



This drawing and the ideas contained herein are protected by copyright. Unauthorised distribution, reproduction or use as part of a submission for development purposes is a breach of copyright. No licence is implied, expressed or assigned unless acknowledged separately in writing. Any rights to distribute or use the information contained in the drawing will be be terminated by SOWDES if the client breaches their obligation to pay all invoices owing to SOWDES. The drawings are conceptual and are not intended to be absolute and therefore may be slightly varied in reality.